
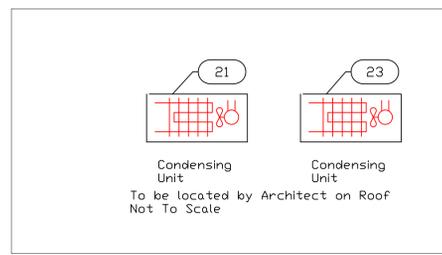


EQUIPMENT SCHEDULE					
ItemNo	Category	Mfr	Model	Quantity	Equipment Remarks
1	Pass-Thru Ice Bin	Krowne	KRPT-2436-10	1	
1.1	Soda System, Parts & Fittings	Krowne	KRPT-6SH	1	
1.2	Soda System, Parts & Fittings	Krowne	KR18-6SH	1	
2	Underbar Add-On Unit	Krowne	KR18-T12	2	
3	Underbar Sink Units	Krowne	KR18-33C	1	
6	Hand Sink	Krowne	KR18-1CD	1	
7	Blender Station	Krowne	KR18-18BD	1	
8	Bottle Cooler	True	TD-65-24-S-HC	1	
9	Bottle Display	Krowne	KR18-12RD	1	
9.1	Bottle Display	Krowne	KR18-24RD	1	
10	Beer Bin	Emjac	BEER BIN	4	
12	Frozen Drink Machine, Non-Carbonated, Cylinder Type	Taylor Company	432	4	By Owner/Operator
13	Work Counters, Stainless	Emjac	COUNTER	1	
13.2	Work Counters, Stainless	Emjac	COUNTER	1	
14	POS System	POS	POS	2	By Owner/Operator
15	Work Table, Cabinet Base Hinged Doors	Emjac	HK-SS-306M	1	
16	Dishwasher, Undercounter	Champion	UL-130	1	
18	Coffee Brewer	BUNN	23001.0003	1	Not in Drawing
21	Walk-In Cooler	Arctic Industries	WALK-IN	1	
	Evaporator for Cooler	Arctic Industries	RL6A117ADAAL	1	
	Remote Condenser Unit for Cooler	Arctic Industries	RFH125E44-D	1	
22	Foodservice Door	Curtron	SPD-20-SS-DBL-6084	1	Not in Drawing
23	Inverter Mini Split Air Conditioner	TGM	MWDR12S/MRDRT12AS	1	
	Remote Condensing Unit	TGM		1	
51	Equipment Stand, Refrigerated Base	True	TRCB-36	1	
52	Charbroiler, Gas, Countertop	Imperial	IRB-36	1	
53	Range, 36", 6 Open Burners	Imperial	IR-6	1	
53.1	Faucet, Kettle / Pot Filler	Krowne	16-182L	1	
54	Gas Fryer, Battery	Imperial	IFSSP-250-OP	1	Existing
55	Gas Floor Fryer	Imperial	IFS-75	1	
56	Refrigerated Work Top	True	TWT-27-HC	1	
57	Conveyor Toaster	Star	QCS1-350	1	
58	Panini Grill	Waring	WPG150	1	
61	Mega Top Sandwich / Salad Preparation Refrigerator	True	TSSU-60-24M-B-ST-HC	2	Existing
62	Reach-In Freezer	True	T-35F-HC	1	Existing
63	Refrigerated Merchandiser	True	GDM-23-HC-TSL01	1	
64	Utility Chase Way	Emjac	POWER CHASE	1	
65	Dish Cabinet	Advance Tabco	DC-184.5	1	
66	Hot Food Well	APW Wyott	W-3VI	2	
67	Microwave Oven	ACP	RMS10DS	2	Existing
71	Undercounter Refrigerator	True	TUC-48-HC	1	
72	Undercounter Refrigerator	True	TUC-72-HC	1	Existing
73	Mop Sink Cabinet	Advance Tabco	9-OPC-84	1	
74	Hand Sink	Advance Tabco	7-PS-20	1	
75	Three (3) Compartment Sink	Advance Tabco	FC-3-1818	1	
76	Work Table, Stainless Steel Top	Advance Tabco	KMS-303	2	
81	Printer	POS	PRINTER	2	By Owner/Operator

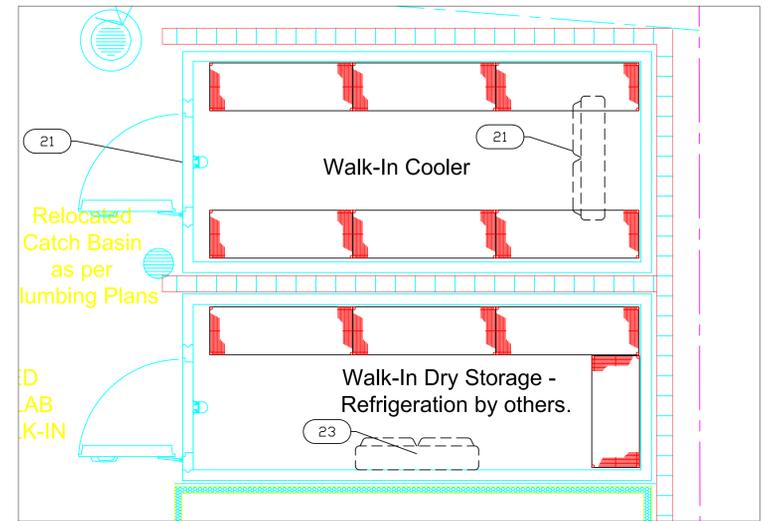

EQUIPMENT LAYOUT

All Dimensions to be verified on the job site.
Actual locations for floor drains, and any ventilating equipment to be determined by Engineer.
Mechanical, Plumbing & Electrical to be checked and verified by Customers MEP Engineer.
Remote Condensing Units to be located by Architect.
Exhaust & Supply fans to be located by Architect.

Nicks Bar & Grill
Main Bar
Hollywood, FL




INTERNATIONAL INC.

2055 W 73rd Street, Miami, FL 33016
Ph: (305)826-8696 Fax: (305)826-9131



No.	Revision/Issue	Date
2	Added Walk-In Cooler	4-24-18
3	Updated Background from Architect	9-20-18
4	Added MEP Details	10-24-18
5	Added Kitchen with MEP Details	11-10-18

Date
Nov 10, 2018
Drawn By
Dayne Gauntlett
Scale
3/8" = 1'0"

Sheet
MB-1

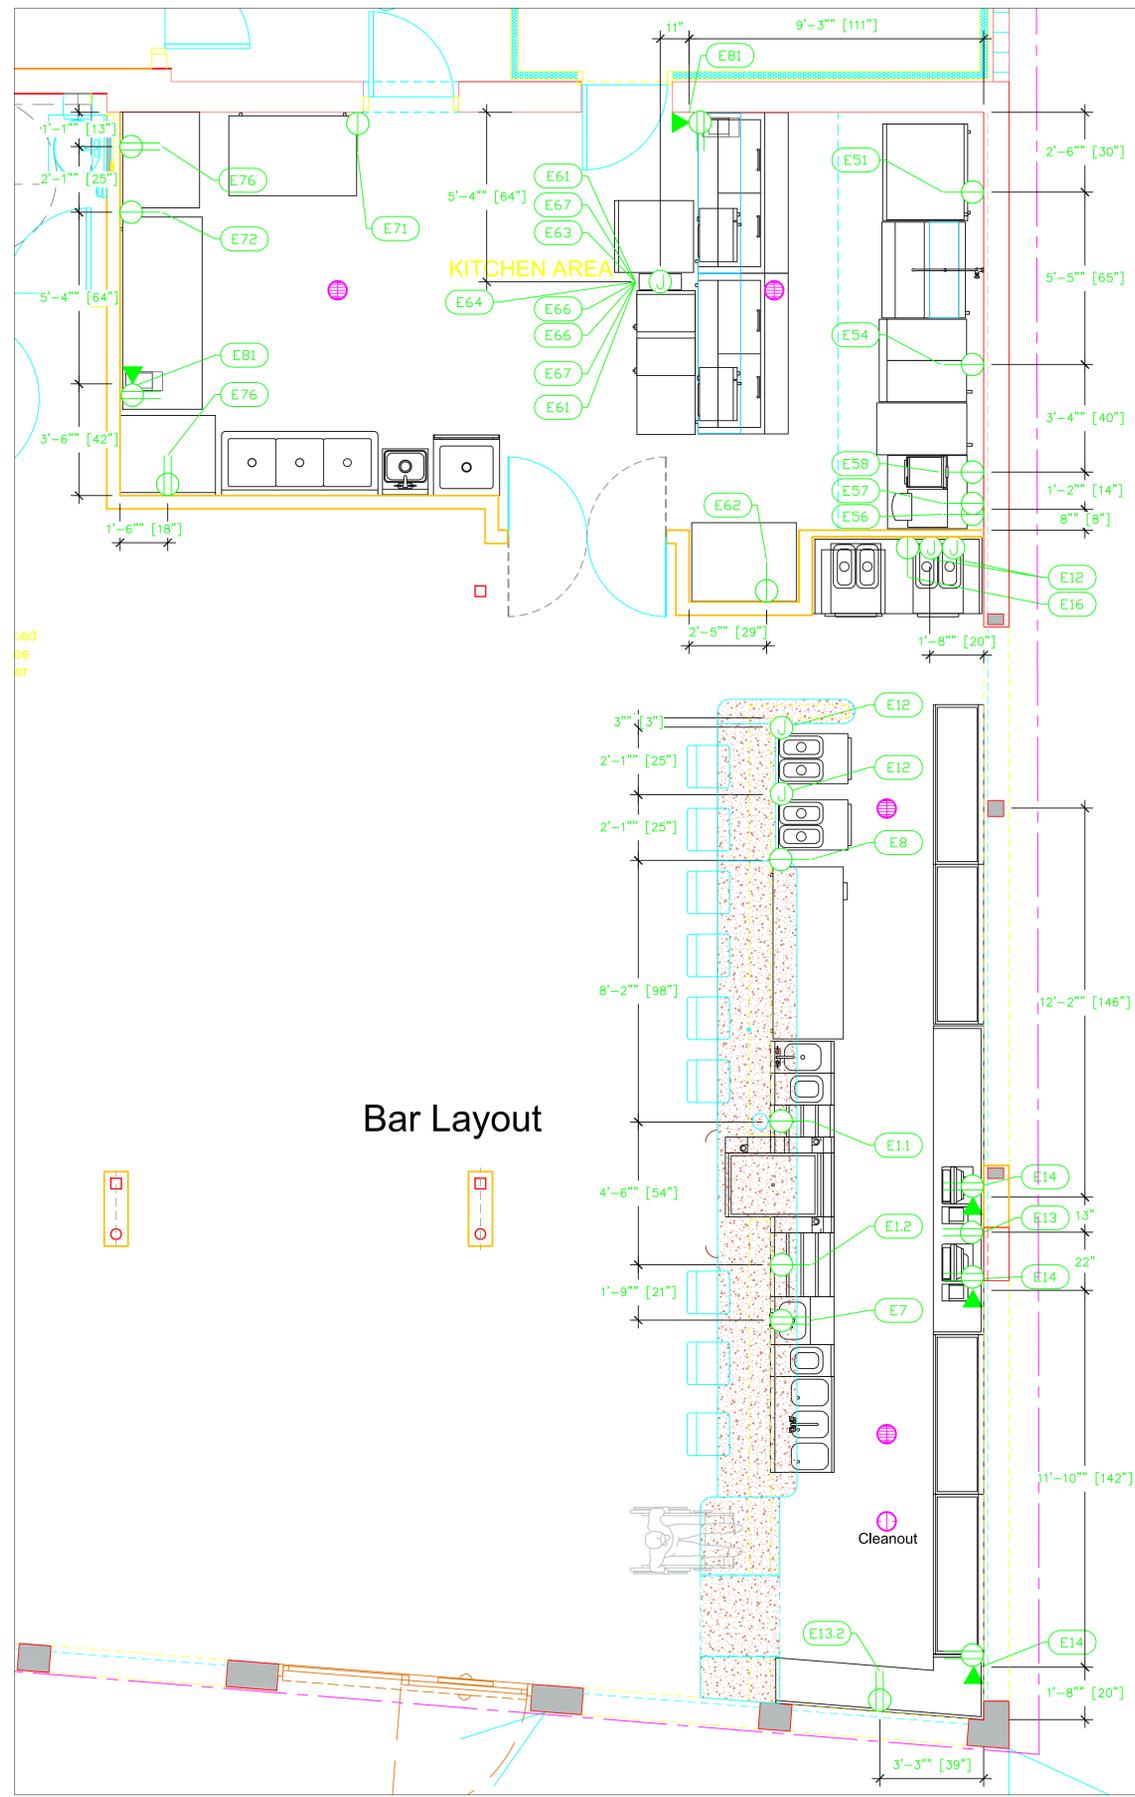

ELECTRICAL SCHEDULE											
ItemNo	Category	Voltage	Cycle	Phase	Amps	Hp	NEMA	ConnectionType	Rough-In AFF	Quantity	Electrical Remarks
1.1	Soda System, Parts & Fittings	120	60	1	10			Simplex	14"	1	Verify Requirements with Vendor
1.2	Soda System, Parts & Fittings	120	60	1	10			Simplex	14"	1	Verify Requirements with Vendor
7	Blender Station	115	60	1	15			Duplex	14"	1	Interconnect with receptacle on #7
8	Bottle Cooler	115	60	1	1.9	1/5	5-15P	Simplex	18"	1	
12	Frozen Drink Machine, Non-Carbonated, Cylinder Type	208-230	60	1	17.0	(2) 1/4		J-Box	18"	4	Verify Requirements with Vendor
13	Work Counters, Stainless	120	60	1	15			Duplex	18"	1	Convenience Outlet
13.2	Work Counters, Stainless	120	60	1	15			Duplex	18"	1	Convenience Outlet
14	POS System	120	60	1	15			Duplex	18"	2	Verify Requirements with Vendor
								DATA	18"	2	Verify Requirements with Vendor
16	Dishwasher, Undercounter	120	60	1	12	1		Simplex	18"	1	
18	Coffee Brewer	120	60	1	11.4		5-15P	Simplex	48"	1	
21	Walk-In Cooler	120	60	1	15			J-box	ceiling	1	Elec. for lights in walk-in
	Evaporator for Cooler	115	60	1	1.6			J-box	ceiling	1	interconnect with Condenser
	Remote Condenser Unit for Cooler	208	60	1	15	1		J-box	ceiling	1	Location by Architect
23	Inverter Mini Split Air Conditioner	220	60	1	4.6			J-Box	96"	1	
	Remote Condensing Unit	220	60	1	5.0			J-Box	n/a	1	Elec from Head Unit.
51	Equipment Stand, Refrigerated Base	115	60	1	5.7	1/5	5-15P	Simplex	18"	1	
54	Gas Fryer, Battery	120	60	1	6.8	1/3		Simplex	18"	1	Elec. for Filter System
56	Refrigerated Work Top	115	60	1	2.0	1/6	5-15P	Simplex	18"	1	
57	Conveyor Toaster	120	50/60	1	13.8			Simplex	48"	1	
58	Panini Grill	120	60	1	15.0			Simplex	48"	1	
61	Mega Top Sandwich / Salad Preparation Refrigerator	115	60	1	6.5	1/3	5-15P	Simplex	n/a	2	Elec. supply from #64 Elec. Panel
62	Reach-In Freezer	115	60	1	9.6	1	5-15P	Simplex	18"	1	
63	Refrigerated Merchandiser	115	60	1	5.4	1/3	5-15P	Simplex	n/a	1	Elec. supply from #64 Elec. Panel
64	Utility Chase Way	115	60	1	tbd			J-Box	n/a	1	Main Incoming for Elec Panel, See Shops
66	Hot Food Well	120	60	1	10.0		5-15P	Simplex	n/a	2	Elec. supply from #64 Elec. Panel
67	Microwave Oven	120	60	1	13		5-15P	Simplex	n/a	2	Elec. supply from #64 Elec. Panel
71	Undercounter Refrigerator	115	60	1	3.0	1/5	5-15P	Simplex	18"	1	
72	Undercounter Refrigerator	115	60	1	4.0	1/4	5-15P	Simplex	18"	1	
76	Work Table, Stainless Steel Top	115	60	1	15			Duplex	n/a	2	Convenience Outlet. See Note E1
81	Printer	115	60	1	15			Duplex	60"	2	Confirm Requirements with Owner
								DATA	60"	2	Confirm Requirements with Owner

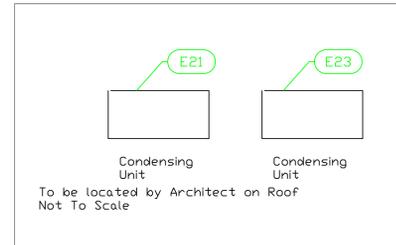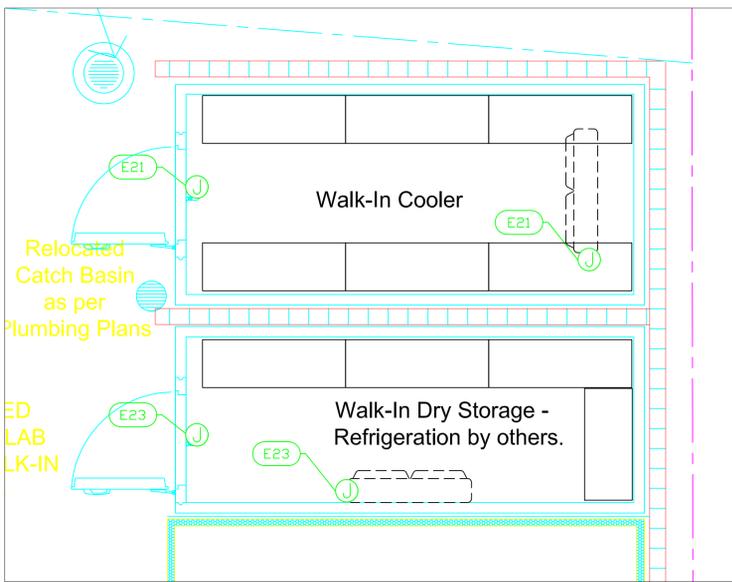

- LEGEND -- ELECTRICAL CONNECTIONS**
- ⊖ DUPLEX RECEPT., 15-AMP, 120-VOLT, GROUND TYPE, HORIZONTAL MOUNT
 - ⊕ SIMPLEX RECEPT., 120-VOLT, GROUND TYPE, HORIZONTAL MOUNT
 - ⊙ SPECIAL PURPOSE OUTLET, GROUND TYPE, HORIZONTAL MOUNT
 - ⊕ JUNCTION BOX, DIRECT CONNECTION
 - ⊖ DISCONNECT SWITCH, DIRECT CONNECTION
 - ⊙ FLOOR/CEILING RECEPTACLE AS INDICATED
 - ▲ (2) Telephone + (2) Data
 - FIELD CONNECTIONS
 - HARD WIRE CONNECTION POINT AT MACHINE

NOTE # E2.
ALL NATIONAL, STATE, AND LOCAL CODES SHALL APPLY.

NOTE # E3.
ALL ELECTRICAL CONNECTIONS AND HARDWARE REQUIRED TO BE PROVIDED BY ELECTRICAL CONTRACTOR.

NOTE # E4.
ALL JUNCTION BOXES, OUTLETS, ETC. TO BE LOCATED SO AS TO NOT INTERFERE WITH EQUIPMENT.

NOTE # E5.
ALL RELAYS, CONTRACTORS, STARTERS, AND SWITCHES REQUIRED FOR EXHAUST & SUPPLY FANS TO BE PROVIDED BY ELECTRICAL CONTRACTOR UNLESS SPECIFIED.

NOTE # E6.
ELECTRICAL CONTRACTOR TO INTERCONNECT DISHMACHINE TO EXHAUST FAN FOR DISHMACHINE SO THAT THE FAN RUNS WHEN THE DISHMACHINE IS IN OPERATION.

NOTE # E7.
ELECTRICAL CONTRACTOR TO INSTALL TABLE LIMIT SWITCH TO END OF CLEAN DISHTABLE TO THAT MACHINE STOPS WHEN SWITCH IS DEPRESSED.

NOTE # E8.
ELECTRICAL CONTRACTOR TO CONNECT DRAIN LINE HEATER, PAN HEATER AND DDOR HEATER FOR WALK-IN FREEZER.

Equipment ELECTRICAL Service Requirements

All Dimensions to be verified on the job site. Actual locations for floor drains, and any ventilating equipment to be determined by Engineer. Mechanical, Plumbing & Electrical to be checked and verified by Customers MEP Engineer. Remote Condensing Units to be located by Architect. Exhaust & Supply fans to be located by Architect.

Nicks Bar & Grill
Main Bar
Hollywood, FL

uni-source SUPPLY
INTERNATIONAL INC.

2055 W 73rd Street, Miami, FL 33016
Ph:(305)826-8696 Fax:(305)826-9131


No.	Revision/Issue	Date
2	Added Walk-In Cooler	4-24-18
3	Updated Background from Architect	9-20-18
4	Added MEP Details	10-24-18
5	Added Kitchen with MEP Details	11-10-18

Date
Nov 10, 2018


Drawn By
Dayne Gauntlett

Scale
3/8" = 1'0"

Sheet
MB-2

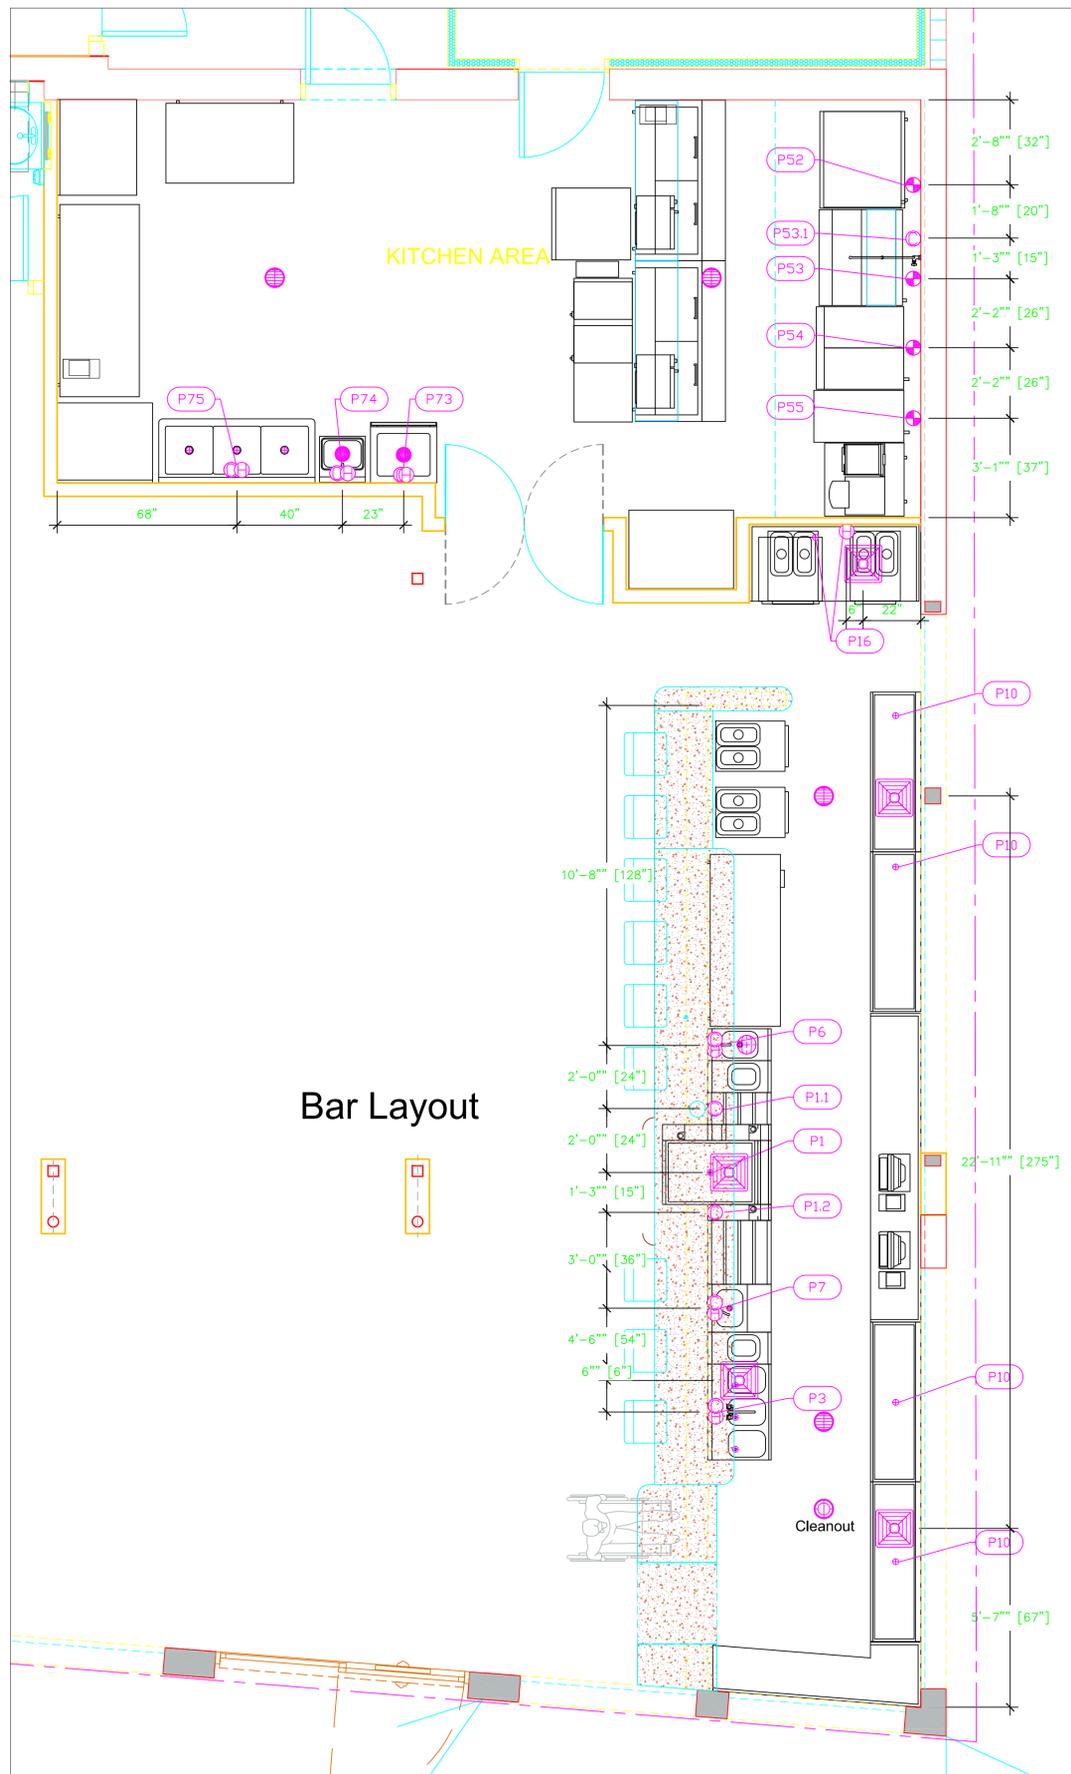

PLUMBING SCHEDULE													
ITEM NO.	DESCRIPTION	COLD WATER SIZE	COLD WATER AFF	HOT WATER SIZE	HOT WATER AFF	H&C ROUGH N	DIRECT WASTE SIZE	DIRECT WASTE AFF	INDIRECT WASTE SIZE	GAS SIZE(IN)	GAS MBTU	QTY	PLUMBING REMARKS
1	Pass-Thru Ice Bin								1/2"			1	Waste to Floor Sink
1.1	Soda System, Parts & Fittings	1/2"	30"									1	
1.2	Soda System, Parts & Fittings	1/2"	30"			12"						1	Verify Requirements with Vendor
3	Underbar Sink Units	1/2"	30"	1/2"	30"	12"			(3) 1-1/2"			1	Waste to Floor Sink
6	Hand Sink	1/2"	30"	1/2"	30"	12"			1"			1	Waste to Funnel Floor Drain
7	Blender Station								1"			1	
10	Beer Bin								1"			4	Waste to Floor Sink
16	Dishwasher, Undercounter			1/2"	6"	12"			5/8"			1	Waste to Floor Sink
18	Coffee Brewer	1/4"	36"			12"						1	
21	Walk-In Cooler											1	
	Evaporator for Cooler								1"			1	interconnect refrig with Cond
	Remote Condenser Unit for Cooler											1	interconnect refrig with Evap
23	Inverter Mini Split Air Conditioner								1"			1	
52	Charbroiler, Gas, Countertop									3/4"	90	1	
53	Range, 36", 6 Open Burners									3/4"	227	1	
53.1	Faucet, Kettle / Pot Filler	1/2"	36"			12"						1	
54	Gas Fryer, Battery									3/4"	280	1	
55	Gas Floor Fryer									3/4"	175	1	
73	Mop Sink Cabinet	1/2"	36"	1/2"	36"	36"	2"	Floor				1	
74	Hand Sink	1/2"	38"	1/2"	38"	12"	1-1/2"	24"				1	(1) set of 1" faucet holes, 4" OC, deck mount
75	Three (3) Compartment Sink	1/2"	36"	1/2"	36"	12"			(3) 1-1/2"			1	(1) set of 1/2" faucet holes, 8" OC

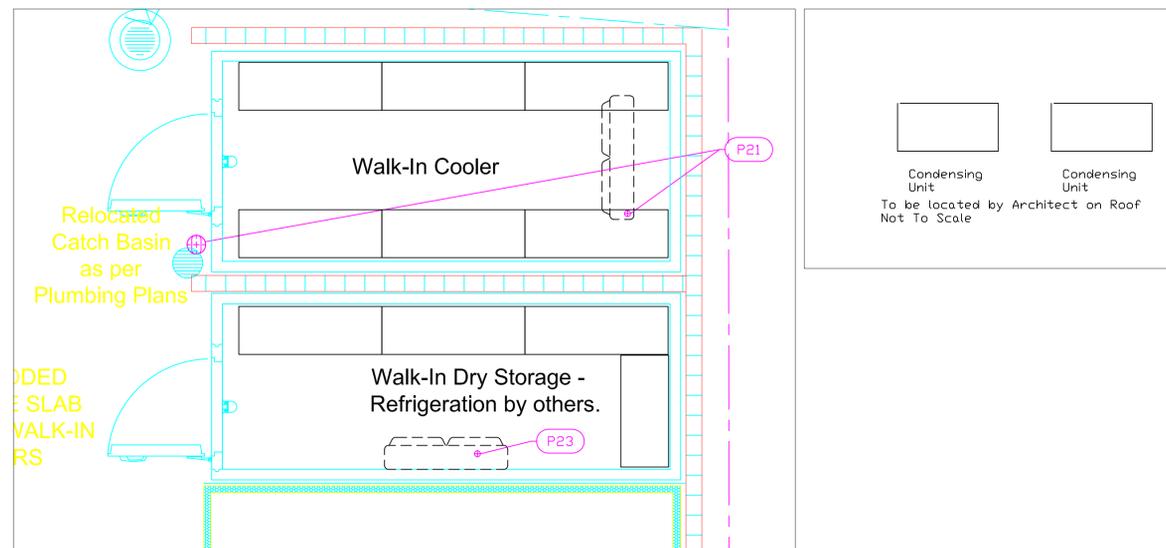

LEGEND -- PLUMBING CONNECTIONS

- HW-HOT WATER, OR CW-COLD WATER
- GAS
- WASTE, DIRECT-CONNECTED
- WASTE, INDIRECT to Floor Sink
- FLOOR DRAIN Josam 30000-A3
- FUNNEL FLOOR DRAIN Josam 30000-E3
- FLOOR SINK Zurn FD-2370-Y-PV4-F

NOTE # P4.
ALL NATIONAL, STATE, AND LOCAL CODES SHALL APPLY

NOTE # P5.
ALL PLUMBING CONNECTIONS TO BE EXTENDED AND INTERCONNECTED TO EQUIPMENT AND ALL HARDWARE REQUIRED TO BE PROVIDED BY PLUMBING CONTRACTOR

NOTE # P6.
PLUMBING CONTRACTOR TO VERIFY THAT ALL EQUIPMENT IS INSTALLED WITH THE APPROPRIATE GAS PRESSURE AND REGULATORS

NOTE # P7.
ALL WASTE LINES AND CONDENSATE LINES TO BE EXTEND FROM EQUIPMENT TO FLOOR DRAINS BY PLUMBING CONTRACTOR.

Equipment PLUMBING Service Requirements

All Dimensions to be verified on the job site. Actual locations for floor drains, and any ventilating equipment to be determined by Engineer. Mechanical, Plumbing & Electrical to be checked and verified by Customers MEP Engineer. Remote Condensing Units to be located by Architect. Exhaust & Supply fans to be located by Architect.

Nicks Bar & Grill
Main Bar
Hollywood, FL







INTERNATIONAL INC.

2055 W 73rd Street, Miami, FL 33016
Ph:(305)826-8696 Fax:(305)826-9131

No.	Revision/Issue	Date
2	Added Walk-In Cooler	4-24-18
3	Updated Background from Architect	9-20-18
4	Added MEP Details	10-24-18
5	Added Kitchen with MEP Details	11-10-18

Date
Nov 10, 2018
Drawn By
Dayne Gauntlett
Scale
1/4" = 1'0"

Sheet
MB-3

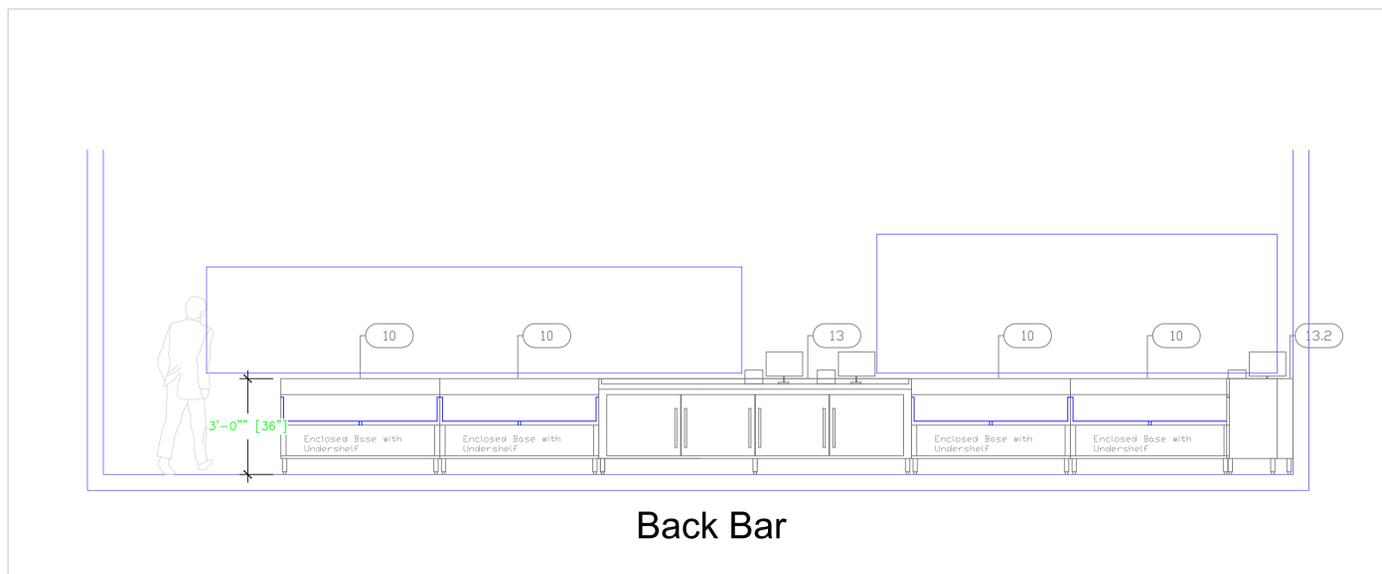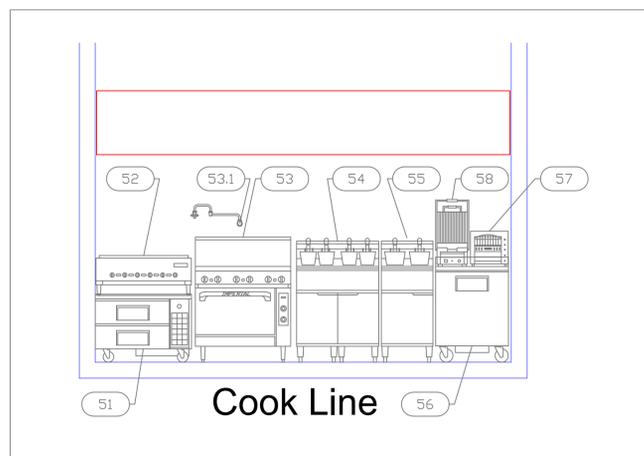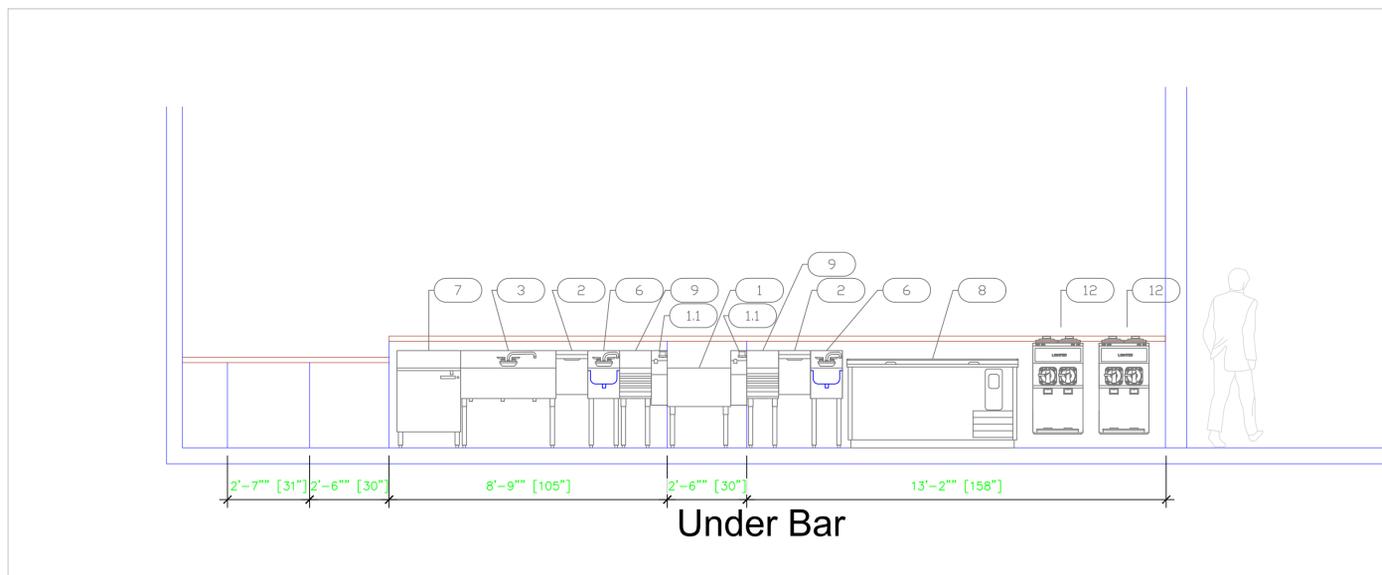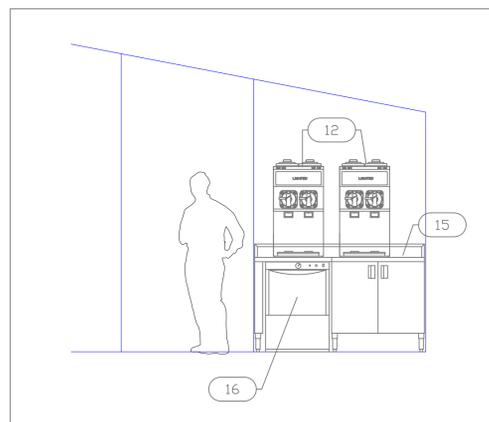

Nicks Bar & Grill
Main Bar
 Hollywood, FL



INTERNATIONAL INC.

2055 W 73rd Street, Miami, FL 33016
 Ph: (305) 826-8696 Fax: (305) 826-9131

No.	Revision/Issue	Date
2	Added Walk-In Cooler	4-24-18
3	Updated Background from Architect	9-20-18
4	Added MEP Details	10-24-18
5	Added Kitchen with MEP Details	11-10-18

Date
Nov 10, 2018
 Drawn By
Dayne Gauntlett
 Scale
3/8" = 1'

Sheet
MB-4